

PROPOSED REMEDIAL WORKS

1:250

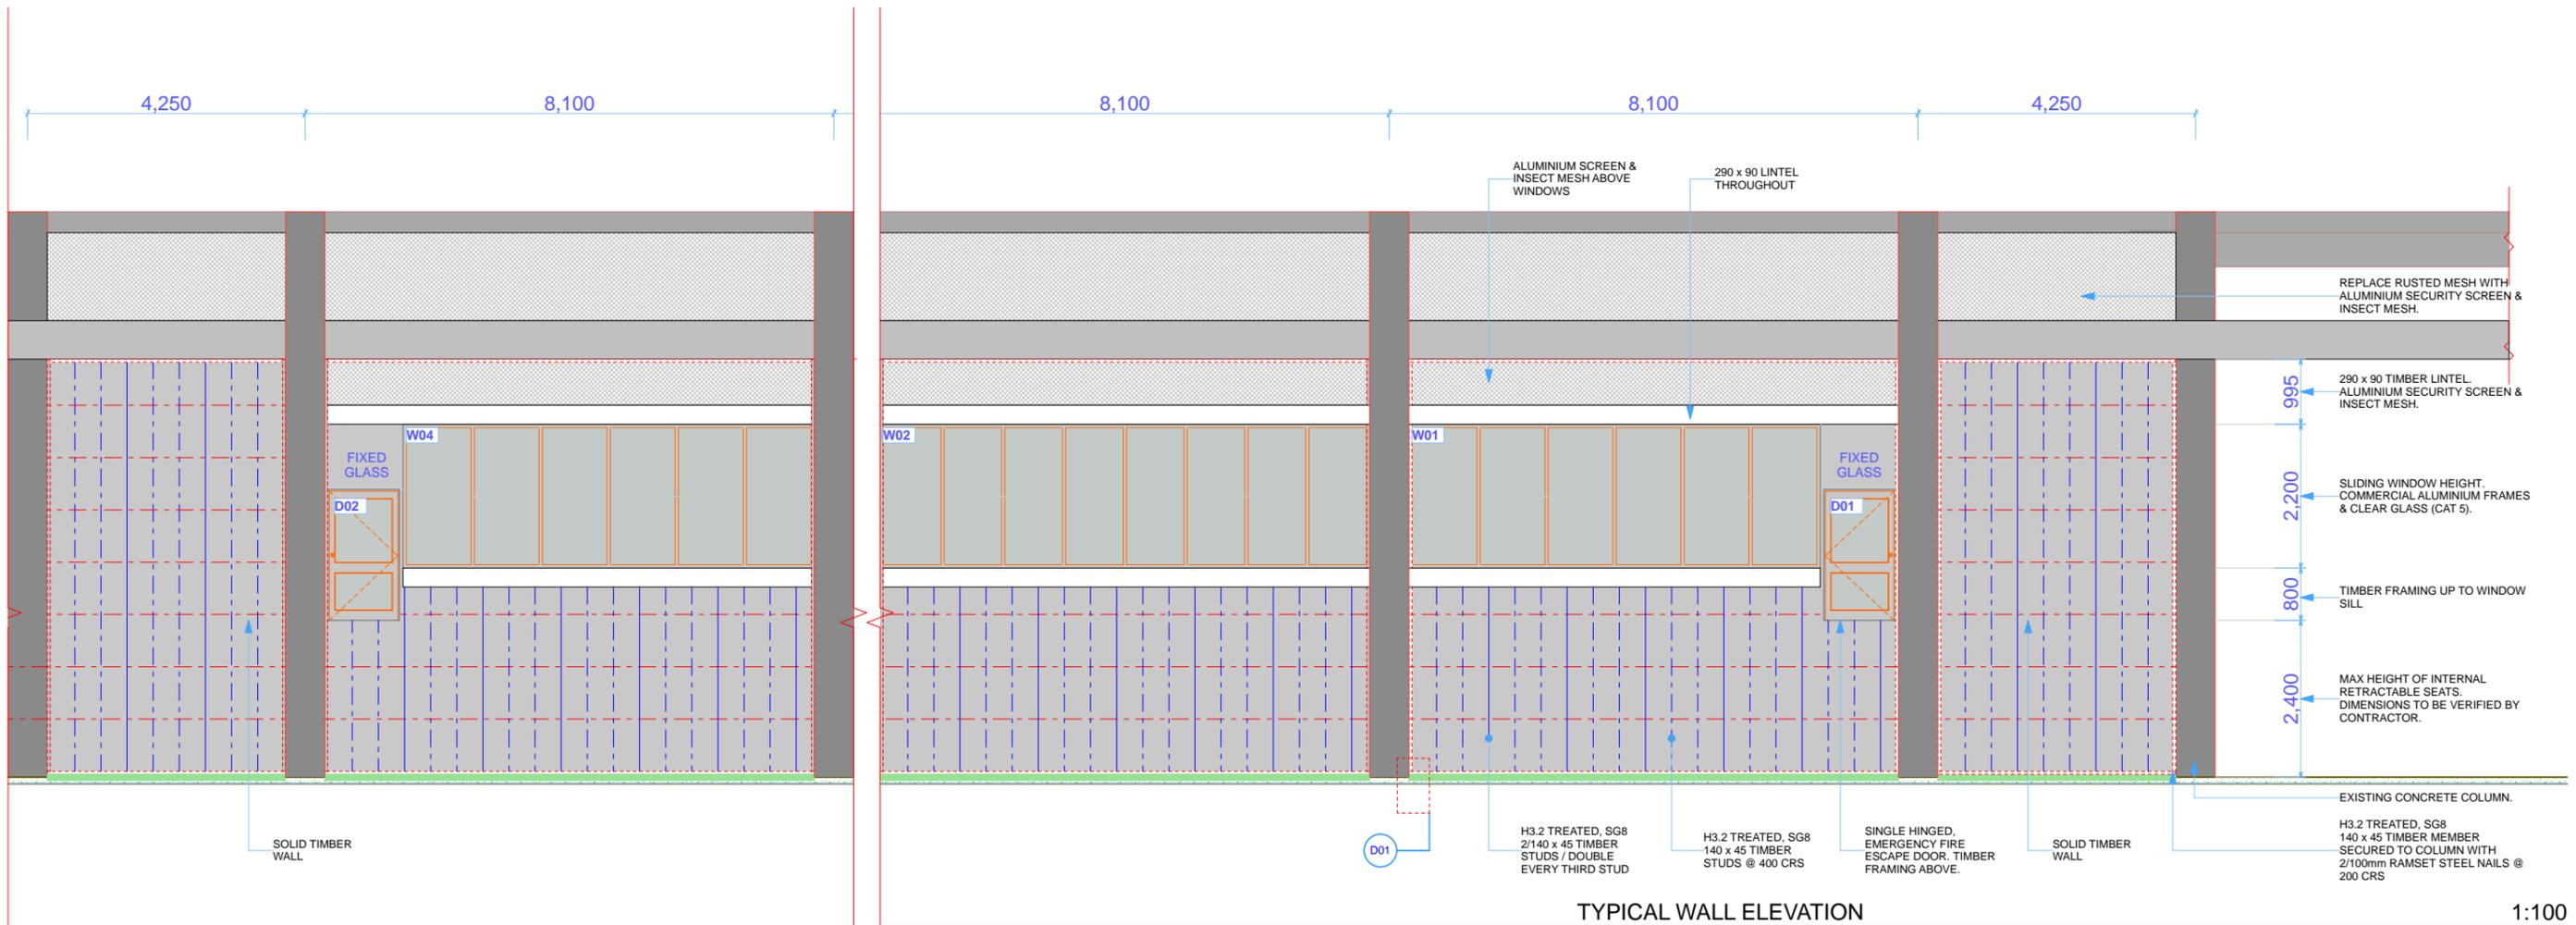
NOTES:
FOR CONSTRUCTION

Client:
SPORTS ARENA
Project Name:
ROLLER DOOR ENCLOSURE
TEREORA
Rarotonga, Cook Islands

Drawn by:

COOK ISLANDS INVESTMENT CORPORATION
(SPECIAL PROJECTS UNIT)
PHONE: (+682) 23 139

SHEET: **201**
SHEET TITLE: SCOPE OF WORKS
SCALE: 1:250 (AT A3)
ISSUED: 24/05/2019



1:100

NOTES:

FOR CONSTRUCTION

Client:

SPORTS ARENA

Project Name:

ROLLER DOOR ENCLOSURE

TEREORA

Rarotonga, Cook Islands

Drawn by:



COOK ISLANDS INVESTMENT CORPORATION (SPECIAL PROJECTS UNIT)

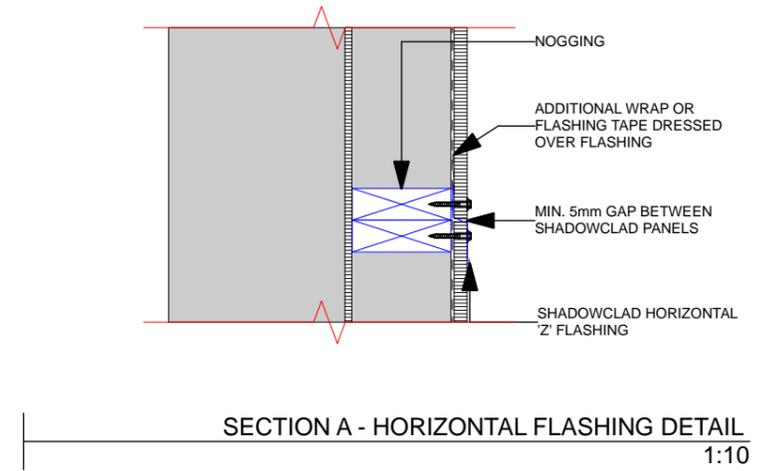
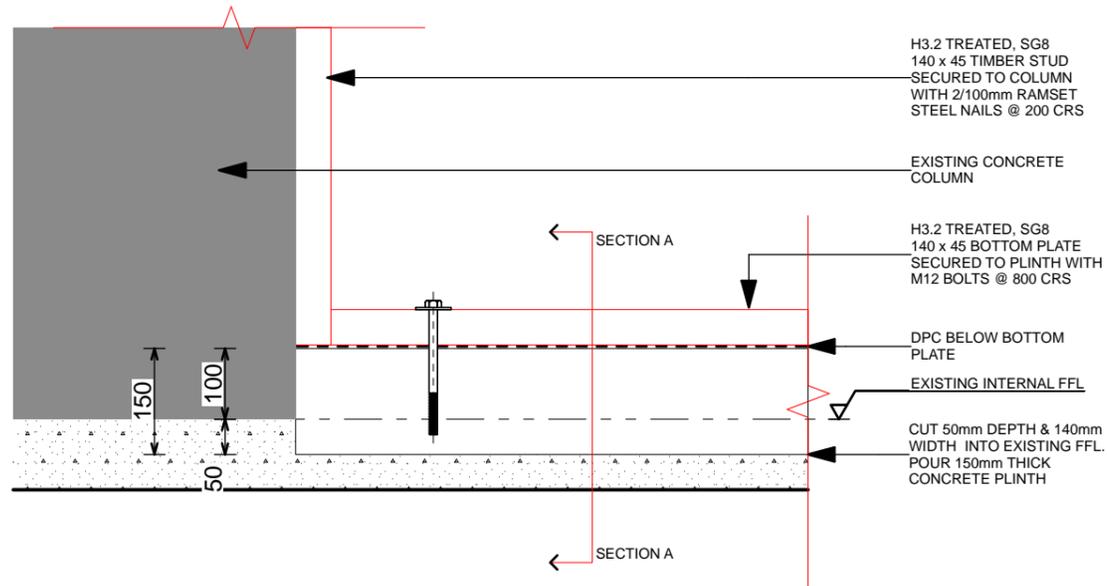
PHONE: (+682) 23 139

SHEET: **202**



SHEET TITLE: TYPICAL WALL ELEVATION

SCALE: 1:100 (AT A3)


ISSUED: 24/05/2019




1 Detail 1:10

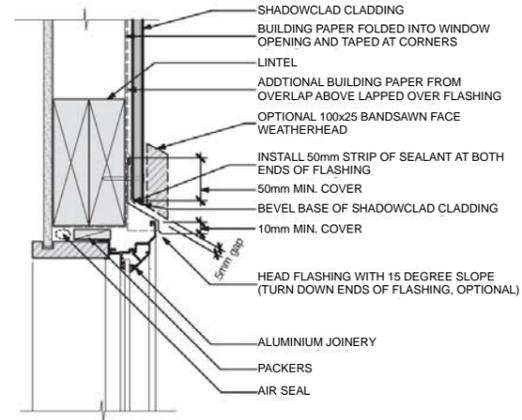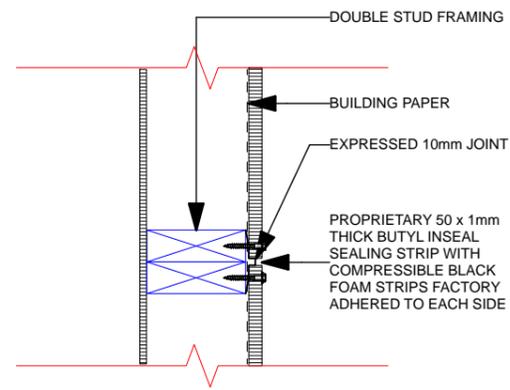


ALUMINIUM WINDOW HEAD DETAIL 1:10

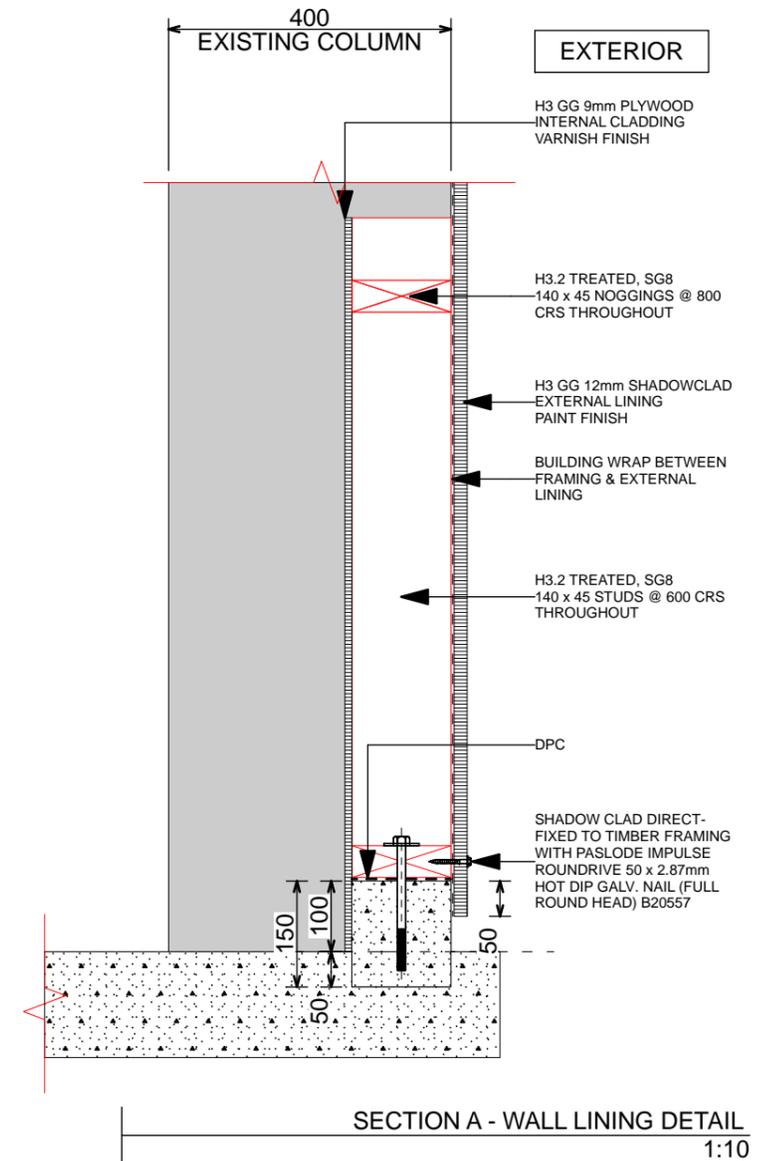

SECTION A - WALL LINING DETAIL 1:10

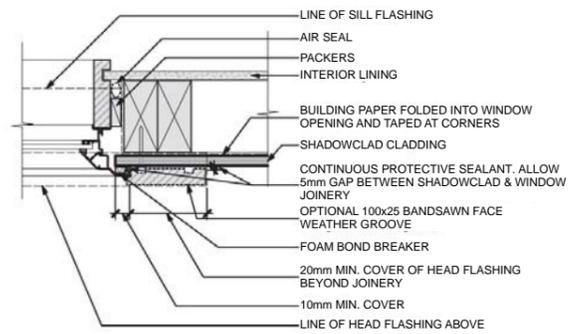

ALUMINIUM WINDOW JAMB DETAIL 1:10

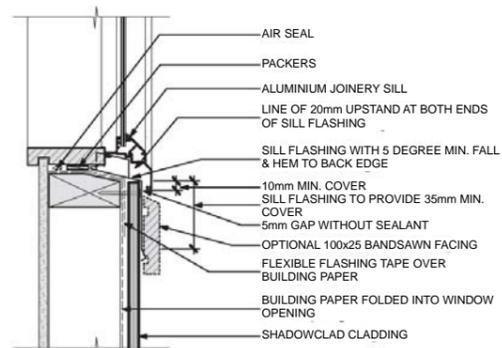

ALUMINIUM WINDOW SILL DETAIL 1:10

- GENERAL NOTES:**
- All dimensions and levels must be verified by builder prior to construction.
 - All dimensions are in millimeters (mm) unless stated otherwise.
 - Sewage and sanitation design and report to be produced by Contractor, or any Public Health approved Sanitation Engineer.
 - Plumbing and electrical plans to be produced by Contractor.
 - Kitchen cabinetry and custom joinery to be designed and manufactured by Contractor.
 - Colours of paint, stain or window and door joinery to be confirmed by Owner.

FOR CONSTRUCTION

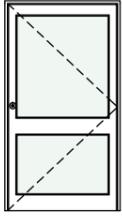
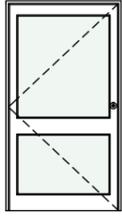
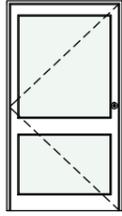
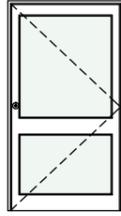
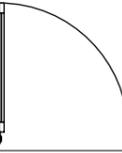
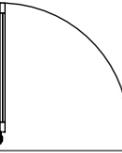
DRAWN BY:
COOK ISLANDS INVESTMENT CORPORATION - SPECIAL PROJECTS UNIT



SHEET: **203**





SHEET TITLE: DETAILS

SCALE: AS SHOWN (AT A3)
REVISION:
ISSUED: 24/05/2019
PHONE: (+682) 23 139
EMAIL: ciic.projects@cookislands.gov.ck

Door Schedule				
Door ID	D01	D02	D03	D04
View from Side Opposite to Opening Side				
2D Symbol				
Description	Type 1: Single hinged door	Type 2: Single hinged door	Type 2: Single hinged door	Type 1: Single hinged door
W x H Size	1,100x2,000	1,100x2,000	1,100x2,000	1,100x2,000
Orientation	L	R	R	L
Sill height	2,500	2,500	2,500	2,500
Frame	Standard aluminium (residential)	Standard aluminium (residential)	Standard aluminium (residential)	Standard aluminium (residential)
Finish	White powder coat, anodized silver sill			
Leaf	8.38mm laminated safety glass, 800mm high vision rail	8.38mm laminated safety glass, 800mm high vision rail	8.38mm laminated safety glass, 800mm high vision rail	8.38mm laminated safety glass, 800mm high vision rail
Hardware	To be supplied by manufacturer			
Locks	Full cylinder to be supplied by manufacturer			
Glazing	To meet NZ 4223 standards			

GENERAL NOTES:

    1. DIMENSIONS ARE NOMINAL ROUGH OPENING (TRIM) SIZES.
2. SILL HEIGHTS ARE TO BE TOP OF THE ROUGH OPENING.
3. SILL HEIGHTS REFER TO DIMENSIONS ABOVE RESPECTIVE FFL.
4. HEAD HEIGHTS ARE TO THE UNDERSIDE OF THE ROUGH OPENING.
5. ALL DOORS TO BE KEYED ALIKE.

Window Schedule								
Window ID	W01	W02	W03	W04	W05	W06	W07	W08
View from Side Opposite to Opening Side								
2D Symbol								
Description	Type 1: 6-sash sliding window	Type 2: 8-sash sliding window	Type 2: 8-sash sliding window	Type 1: 6-sash sliding window	Type 1: 6-sash sliding window	Type 2: 8-sash sliding window	Type 2: 8-sash sliding window	Type 1: 6-sash sliding window
W x H Size	6,300x2,200	7,500x2,200	7,500x2,200	6,300x2,200	6,300x2,200	7,500x2,200	7,500x2,200	6,300x2,200
Orientation								
Sill height	3,300	3,300	3,300	3,300	3,300	3,300	3,300	3,300
Frame	Standard aluminium (residential)	Standard aluminium (residential)	Standard aluminium (residential)	Standard aluminium (residential)	Standard aluminium (residential)	Standard aluminium (residential)	Standard aluminium (residential)	Standard aluminium (residential)
Finish	White powder coat	White powder coat	White powder coat	White powder coat	White powder coat	White powder coat	White powder coat	White powder coat
Leaf	8.38mm laminated safety glass	8.38mm laminated safety glass	8.38mm laminated safety glass	8.38mm laminated safety glass	8.38mm laminated safety glass			
Hardware	To be supplied by manufacturer	To be supplied by manufacturer	To be supplied by manufacturer	To be supplied by manufacturer	To be supplied by manufacturer			
Locks	To be supplied by manufacturer	To be supplied by manufacturer	To be supplied by manufacturer	To be supplied by manufacturer	To be supplied by manufacturer			
Glazing	To meet NZS 4223 standards	To meet NZS 4223 standards	To meet NZS 4223 standards	To meet NZS 4223 standards	To meet NZS 4223 standards			

GENERAL NOTES:

1. All dimensions and levels must be verified by builder prior to construction.
2. All dimensions are in millimeters (mm) unless stated otherwise.
3. Sewage and sanitation design and report to be produced by Contractor, or any Public Health approved Sanitation Engineer.
4. Plumbing and electrical plans to be produced by Contractor.
5. Kitchen cabinetry and custom joinery to be designed and manufactured by Contractor.
6. Colours of paint, stain or window and door joinery to be confirmed by Owner.

FOR CONSTRUCTION

DRAWN BY:

COOK ISLANDS INVESTMENT CORPORATION - SPECIAL PROJECTS UNIT



SHEET:

204

SHEET TITLE: DOOR & WINDOW SCHEDULE

SCALE: AS SHOWN (AT A3)

REVISION:

ISSUED: 24/05/2019

PHONE: (+682) 23 139

EMAIL: ciic.projects@cookislands.gov.ck